




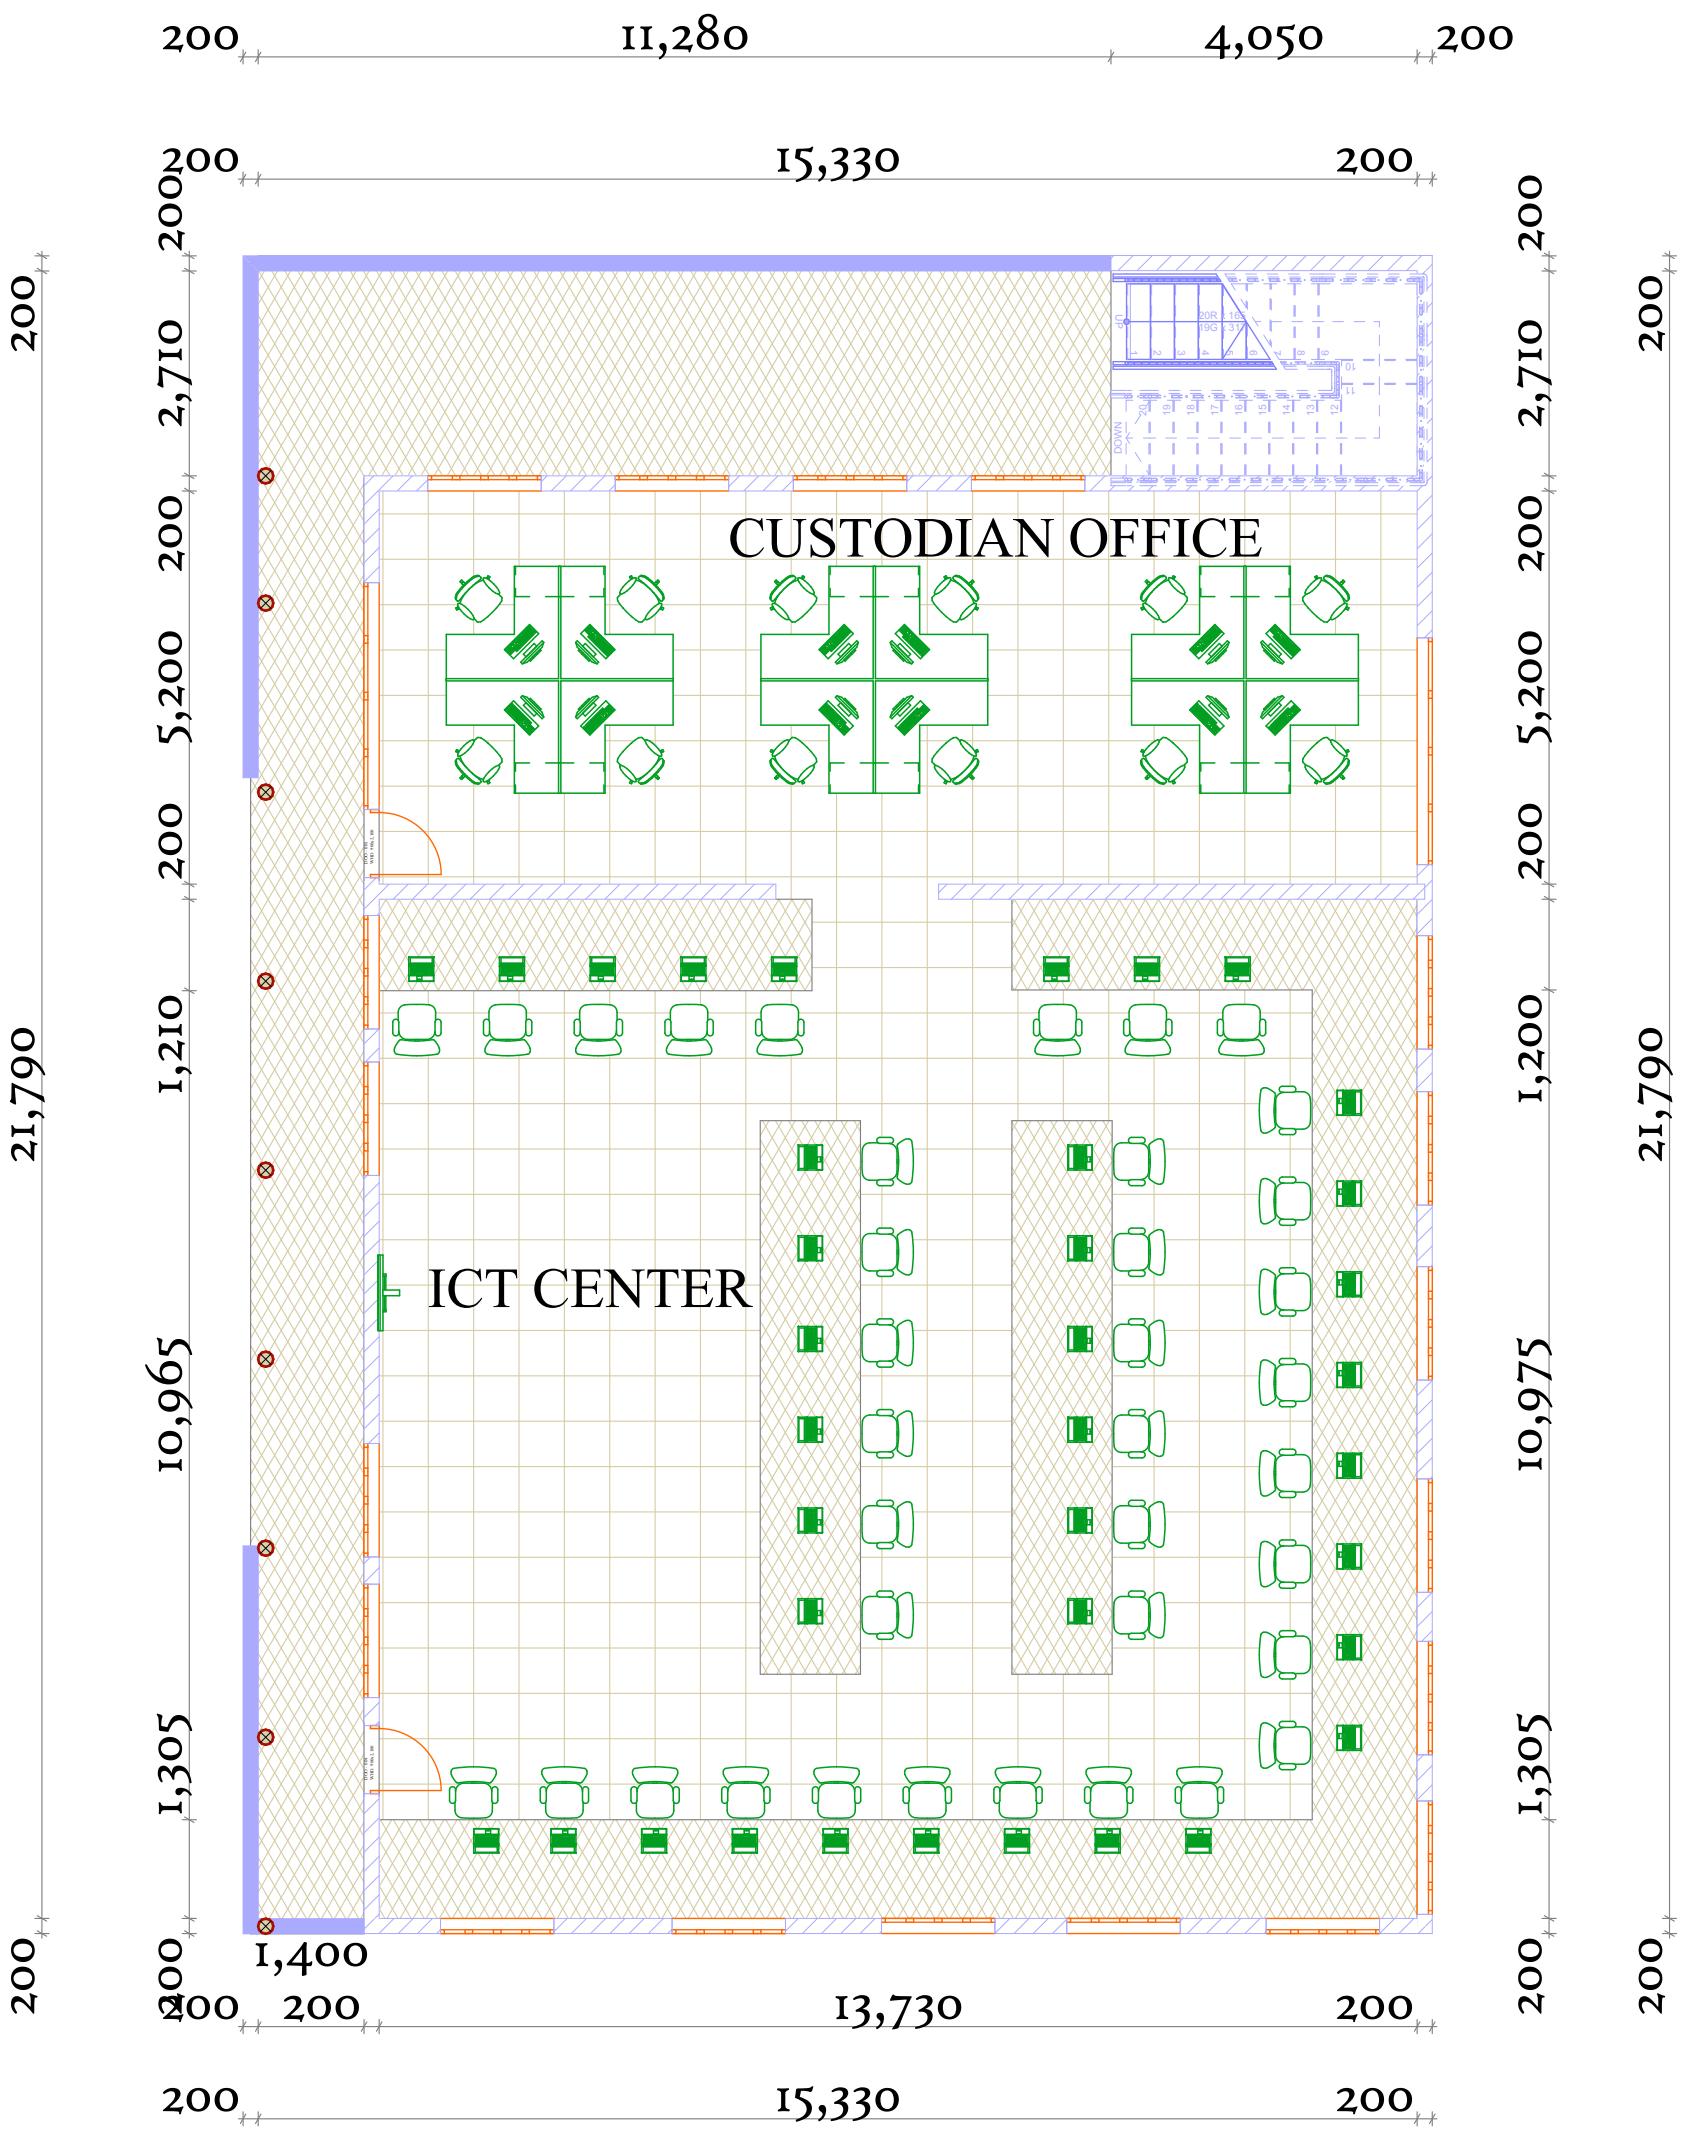

GROUND FLOOR -ICT CENTER LAYOUT (Scale 1:100)

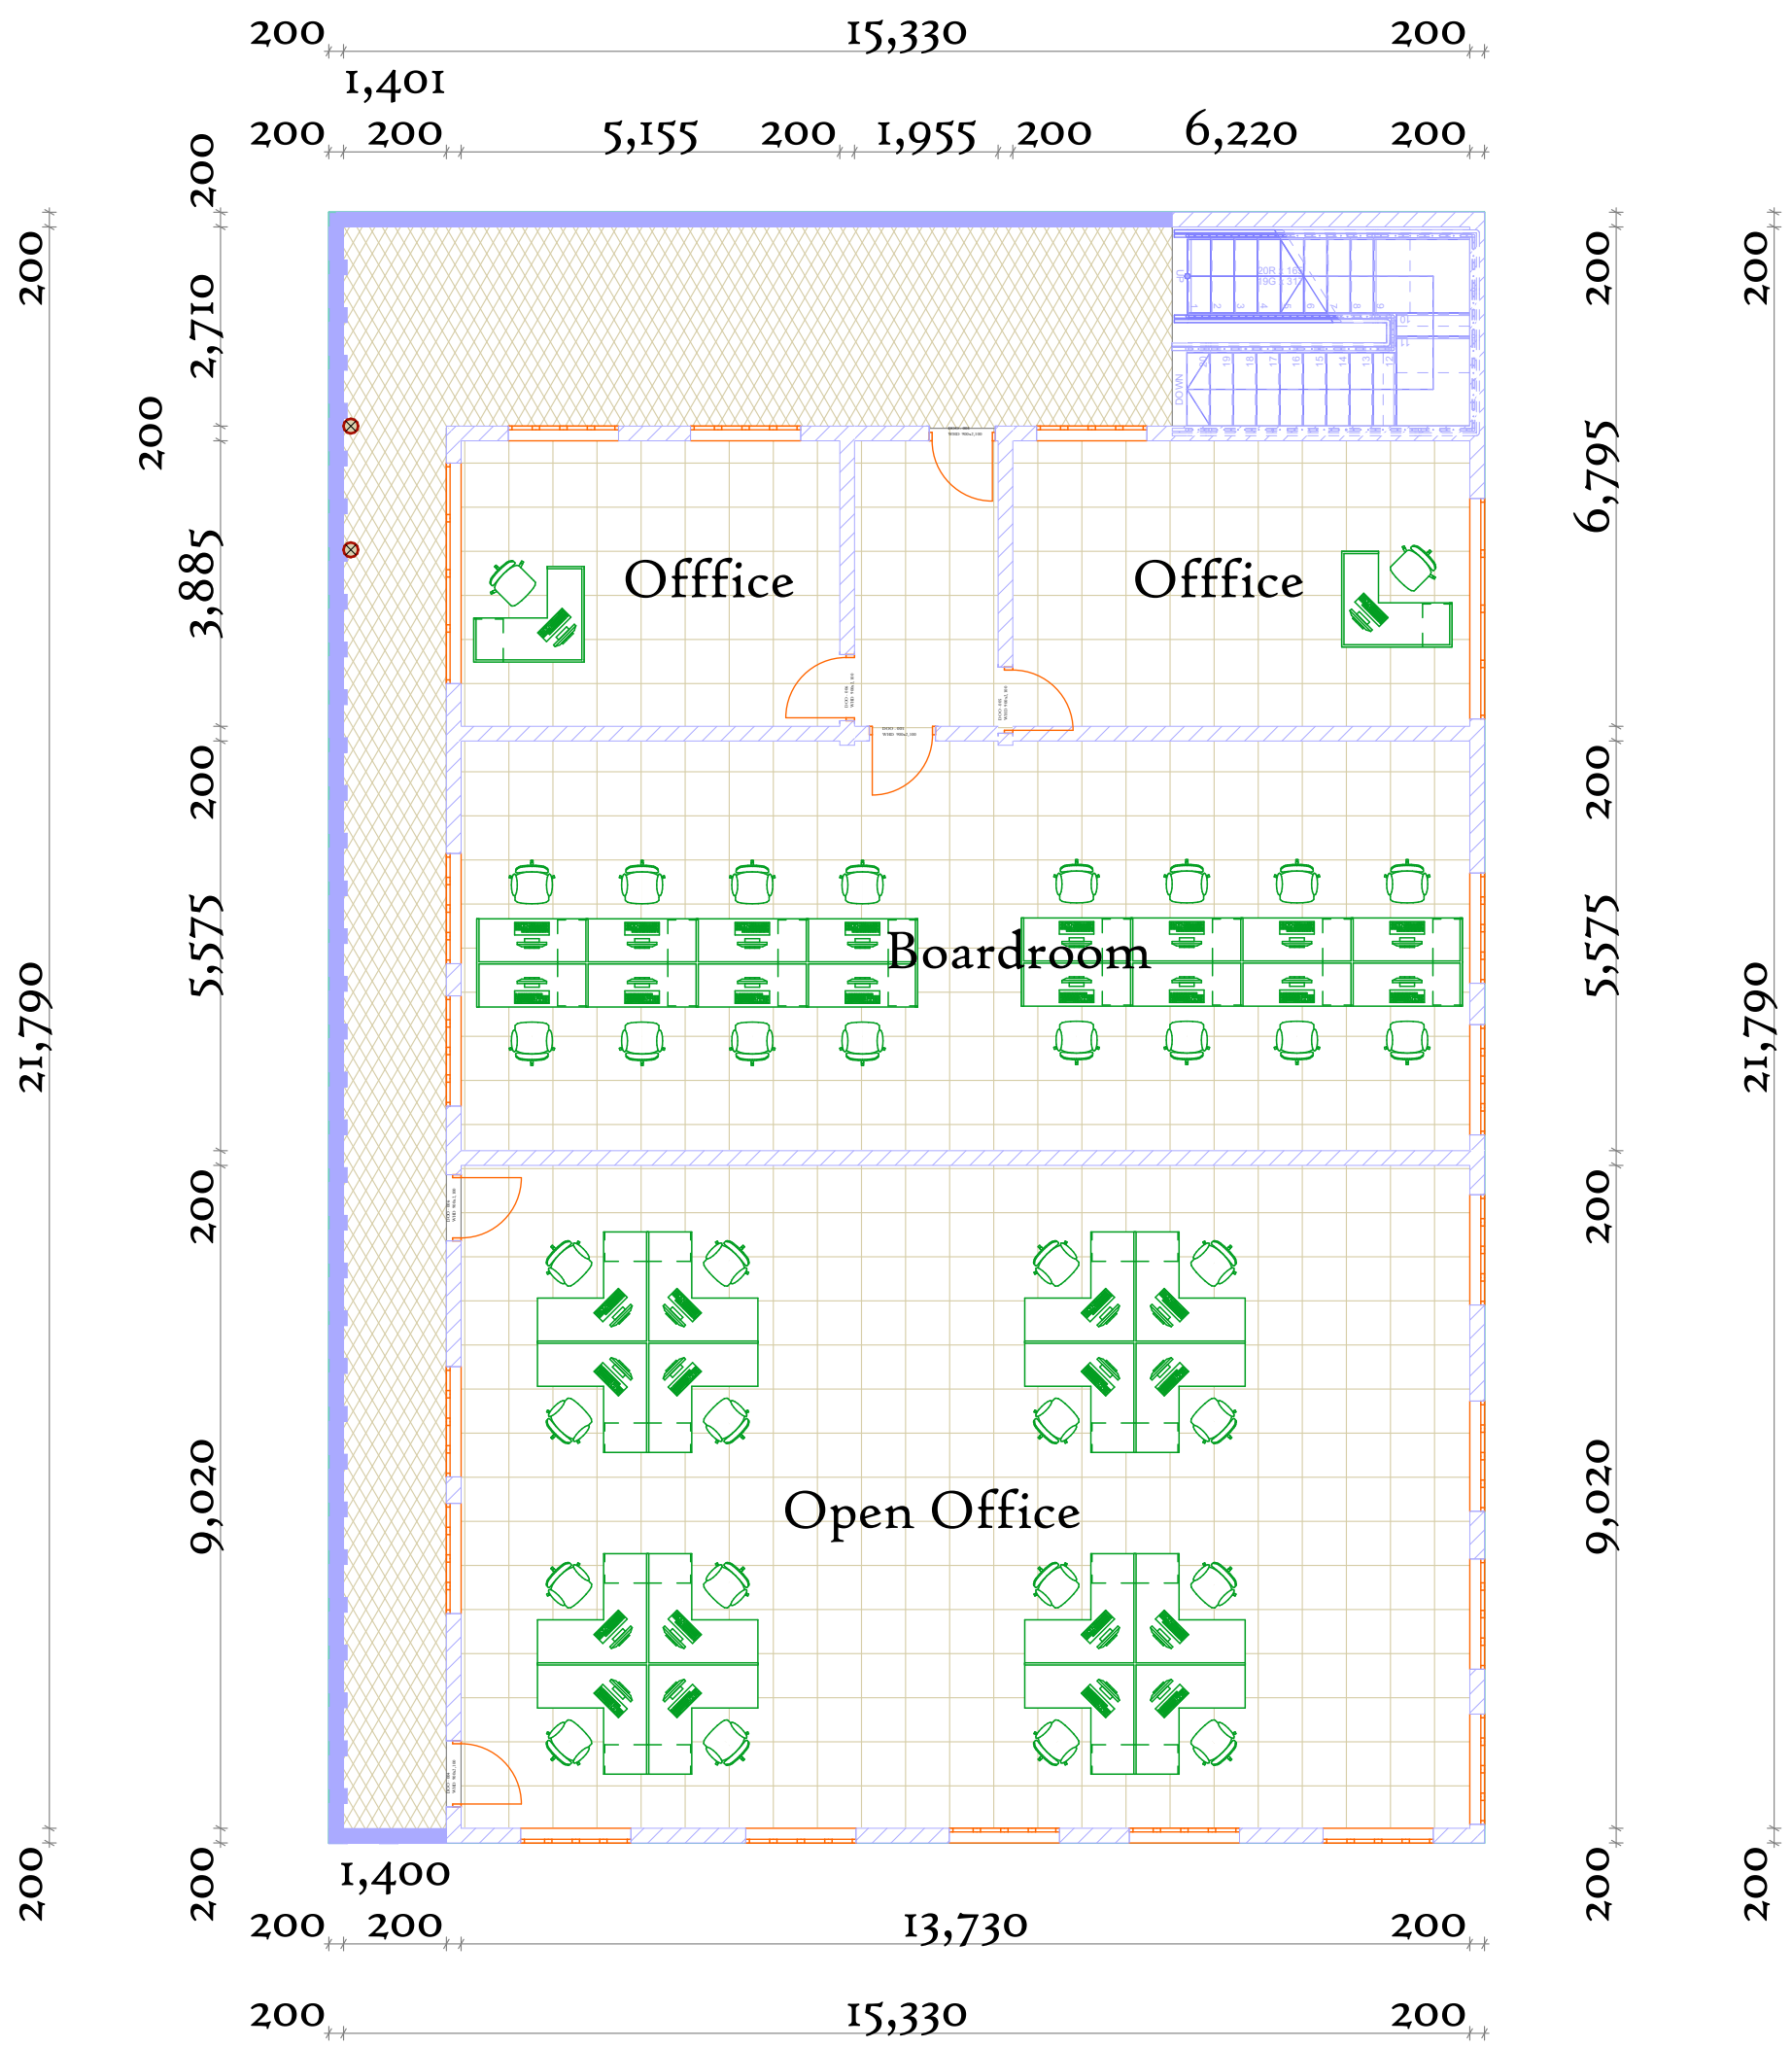

UPPER FLOOR -ICT CENTER LAYOUT (Scale 1:100)

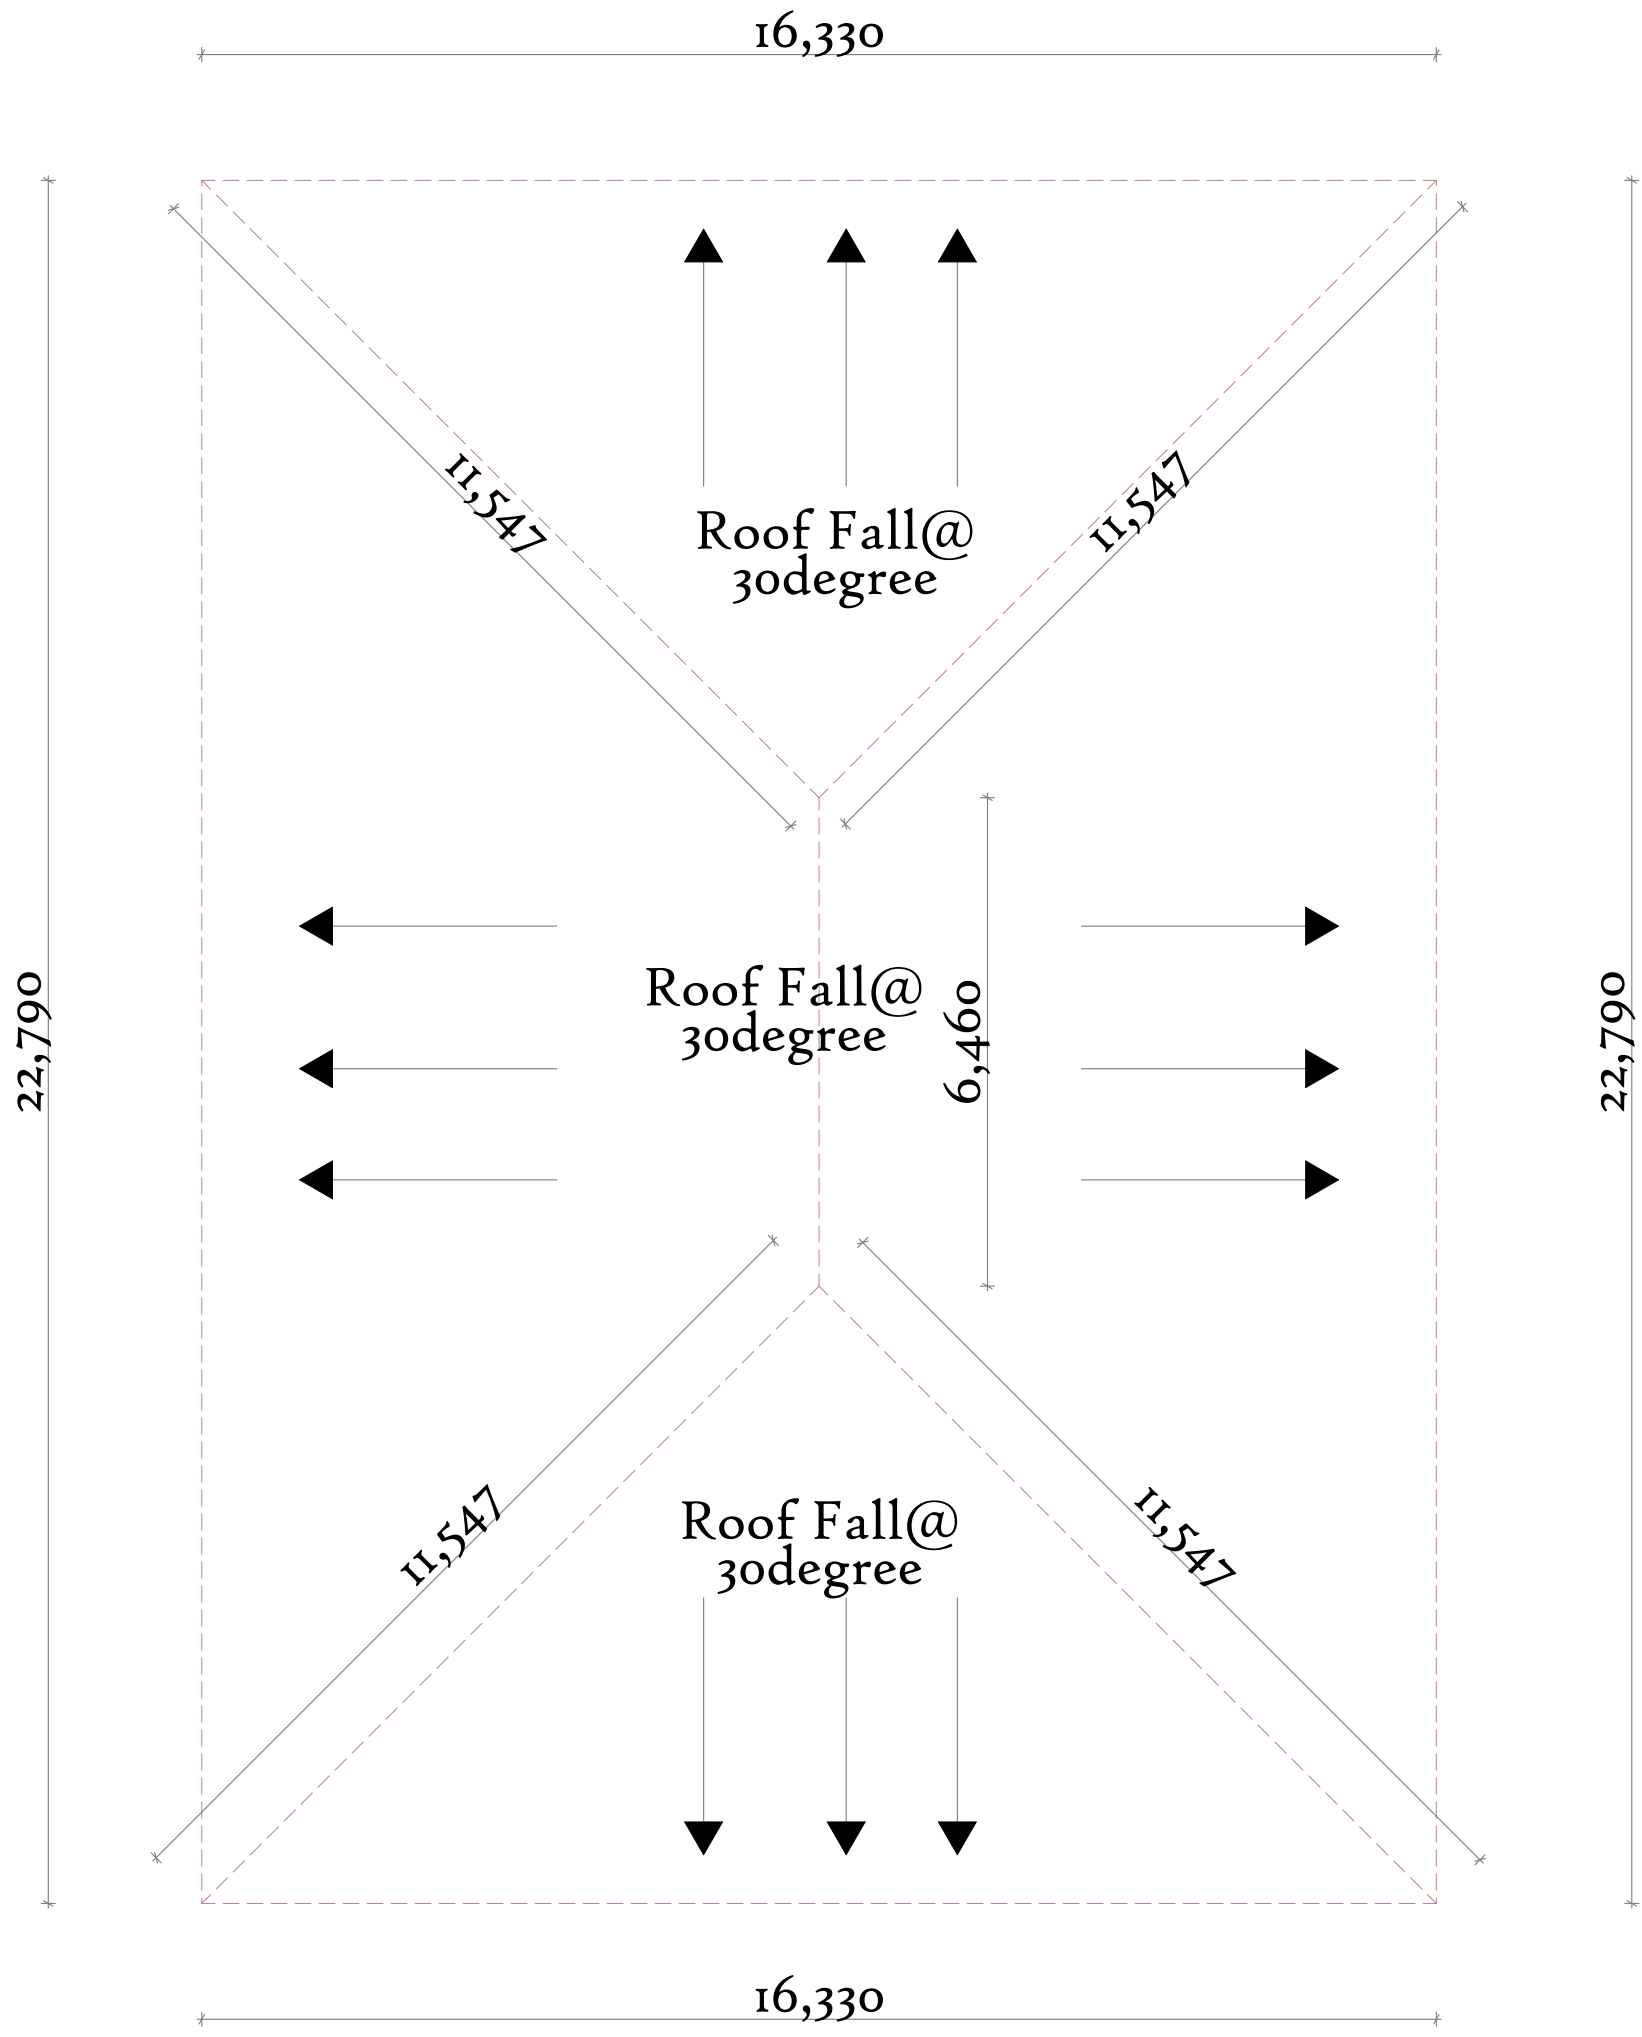

ROOF PLAN -ICT CENTER LAYOUT (Scale 1:100)

NOTES.
GENERAL.
DO NOT SCALE OF THESE DRAWINGS.
ALL DIMENSIONS IN MM UNLESS OTHERWISE SPECIFIED.
ALL LEVELS AND DIMENSIONS SHOULD BE CHECKED BEFORE COMMENCEMENT OF ANY WORK.
ANY DISCREPANCIES TO BE REPORTED TO THE OFFICE OF THE CONSULTANT.
THIS DRAWING IS TO BE READ IN CONJUNCTION WITH SPECIFICATIONS AND ALL OTHER RELEVANT DRAWINGS.

STRUCTURAL.
FOR ALL R.C WORK REFER TO S.E'S DETAILS .
FOUNDATION DEPTH TO BE DETERMINED ON SITE .
ALL WALLS LESS THAN 200MM TO BE REINFORCED WITH HOOP IRON AT ALTERNATE COURSES .

CONSTRUCTION.
EXCAVATIONS,FILLING AND COMPACTION TO BE IN ACCORDANCE WITH ENGINEER'S INSTRUCTIONS .
ALL SOIL UNDER THE SLAB AND AROUND THE EXTERNAL FOUNDATION TO BE TREATED WITH ANTI-TERMITE CONTROL .

PLUMBING.
ALL PLUMBING AND DRAINAGE TO COMPLY WITH CITY COUNCIL'S SPECIFICATIONS .
DRAINS PASSING BENEATH BUILDINGS AND DRIVEWAYS TO BE ENCASED IN 150MM THICK CONCRETE SURROUND.
ALL MECHANICAL WORK MUST BE COORDINATED WITH THE MECHANICAL AND ELECTRICAL ENGINEER'S AND CLARIFICATIONS MADE BEFORE THE WORKS BEGIN.

ALL INSPECTION CHAMBERS COVERS AND FRAMING SHALL BE CAST IRON TO COMPLY WITH BS497.
ALL UNDERGROUND FOUL AND DRAIN PIPES SHALL BE UPVC TO COMPLY WITH BS5255
STORM WATERDRAIN TO COMPLY WITH BS556.

Project Title.
PROPOSED EDUCATION FACILITY .
Client.

Designed by

0722-206-259

Drawing Title
NDALANI TRANING & VOCATIONAL
Layout ID
ICT CENTER
Revisions

Scale
1:100
Date